CONTRACTOR IS RESPONSIBLE TO COORDINATE ALL EQUIPMENT AND MATERIALS WITH ALL OTHER TRADES.

E2W ENGINEERING 161 East Michigan Ave

Suite 200 Kalamazoo, MI 49007 **PHONE:** (269) 373-8000 **FAX:** (269) 373-5641


This drawing, as an instrument of service, is owned by E2W Engineering, LLC. Reproduction of this document is prohibited without express authorization from the engineer. ©2011 E2W Engineering, LLC

LIGHTING NOTES

- DEMO EXISTING UNDERGROUND 480V LIGHTING CIRCUIT AND BASES AS SHOWN. RELOCATE EXISTING POLES AND FIXTURES TO NEW BASES AND RECONNECT BACK INTO EXISTING CIRCUIT AND CONTROLS.
- ALL BELOW GRADE CONDUIT TO BE BURIED MINIMUM 24" BELOW GRADE IN SCHEDULE 40 PVC. PROVIDE LINE MARKER TAPE PER SPECIFICATIONS. GENERATOR AND MAIN
- TRANSFORMER UNDERGROUND CONDUITS TO BE LOCATED A MINIMUM OF 48" BELOW PROVIDE HANDHOLES AT LOCATIONS SHOWN. HANDHOLES TO BE QUAZITE OR EQUAL WITH

LIGHT WHEEL LOADING OF COVERS. PROVIDE COVERS WITH MOLDED IN TEXT FOR

- UTILITIES BURIED. SEE CIVIL PLAN FOR CONTINUATION OF CONDUITS TO EXISTING BUILDING. COORDINATE WITH OWNER PENETRATION INTO EXISTING BUILDING AND ROUTING OF CONDUITS WITHIN
- EXISTING BUILDING. SEE DETAIL SHEET FOR POLE BASE DETAILS. EXACT LOCATIONS OF POLE BASES TO BE
- COORDINATED WITH CIVIL AND CM. PROVIDE 208V AND 120V POWER TO GENERATOR FOR OIL HEATER AND LIGHTS/RECEPTACLES. HEATER, LIGHTS AND RECEPTACLE INSTALLED BY GENERATOR
- MANUFACTURER. PROVIDE DATA LINE FOR REMOTE COMMUNICATIONS. COORDINATE EXACT LOCATIONS OF GENERATOR AND TRANSFORMER WITH CIVIL, CM AND
- COORDINATE ANY PRIMARY METERING AND CONDUIT REQUIREMENTS WITH LOCAL UTILITY
- SEE DETAIL SHEET FOR PAD DETAILS AND GROUNDING REQUIREMENTS FOR GENERATOR
- MOUNT FIXTURE TYPE 'JJ' MINIMUM 8' AWAY FROM SIGN. SEE POLE BASE DETAIL ON DETAIL SHEET. AIM FIXTURE AND ADJUST BARN DOORS TO EVENLY ILLUMINATE SIGN WITH NO

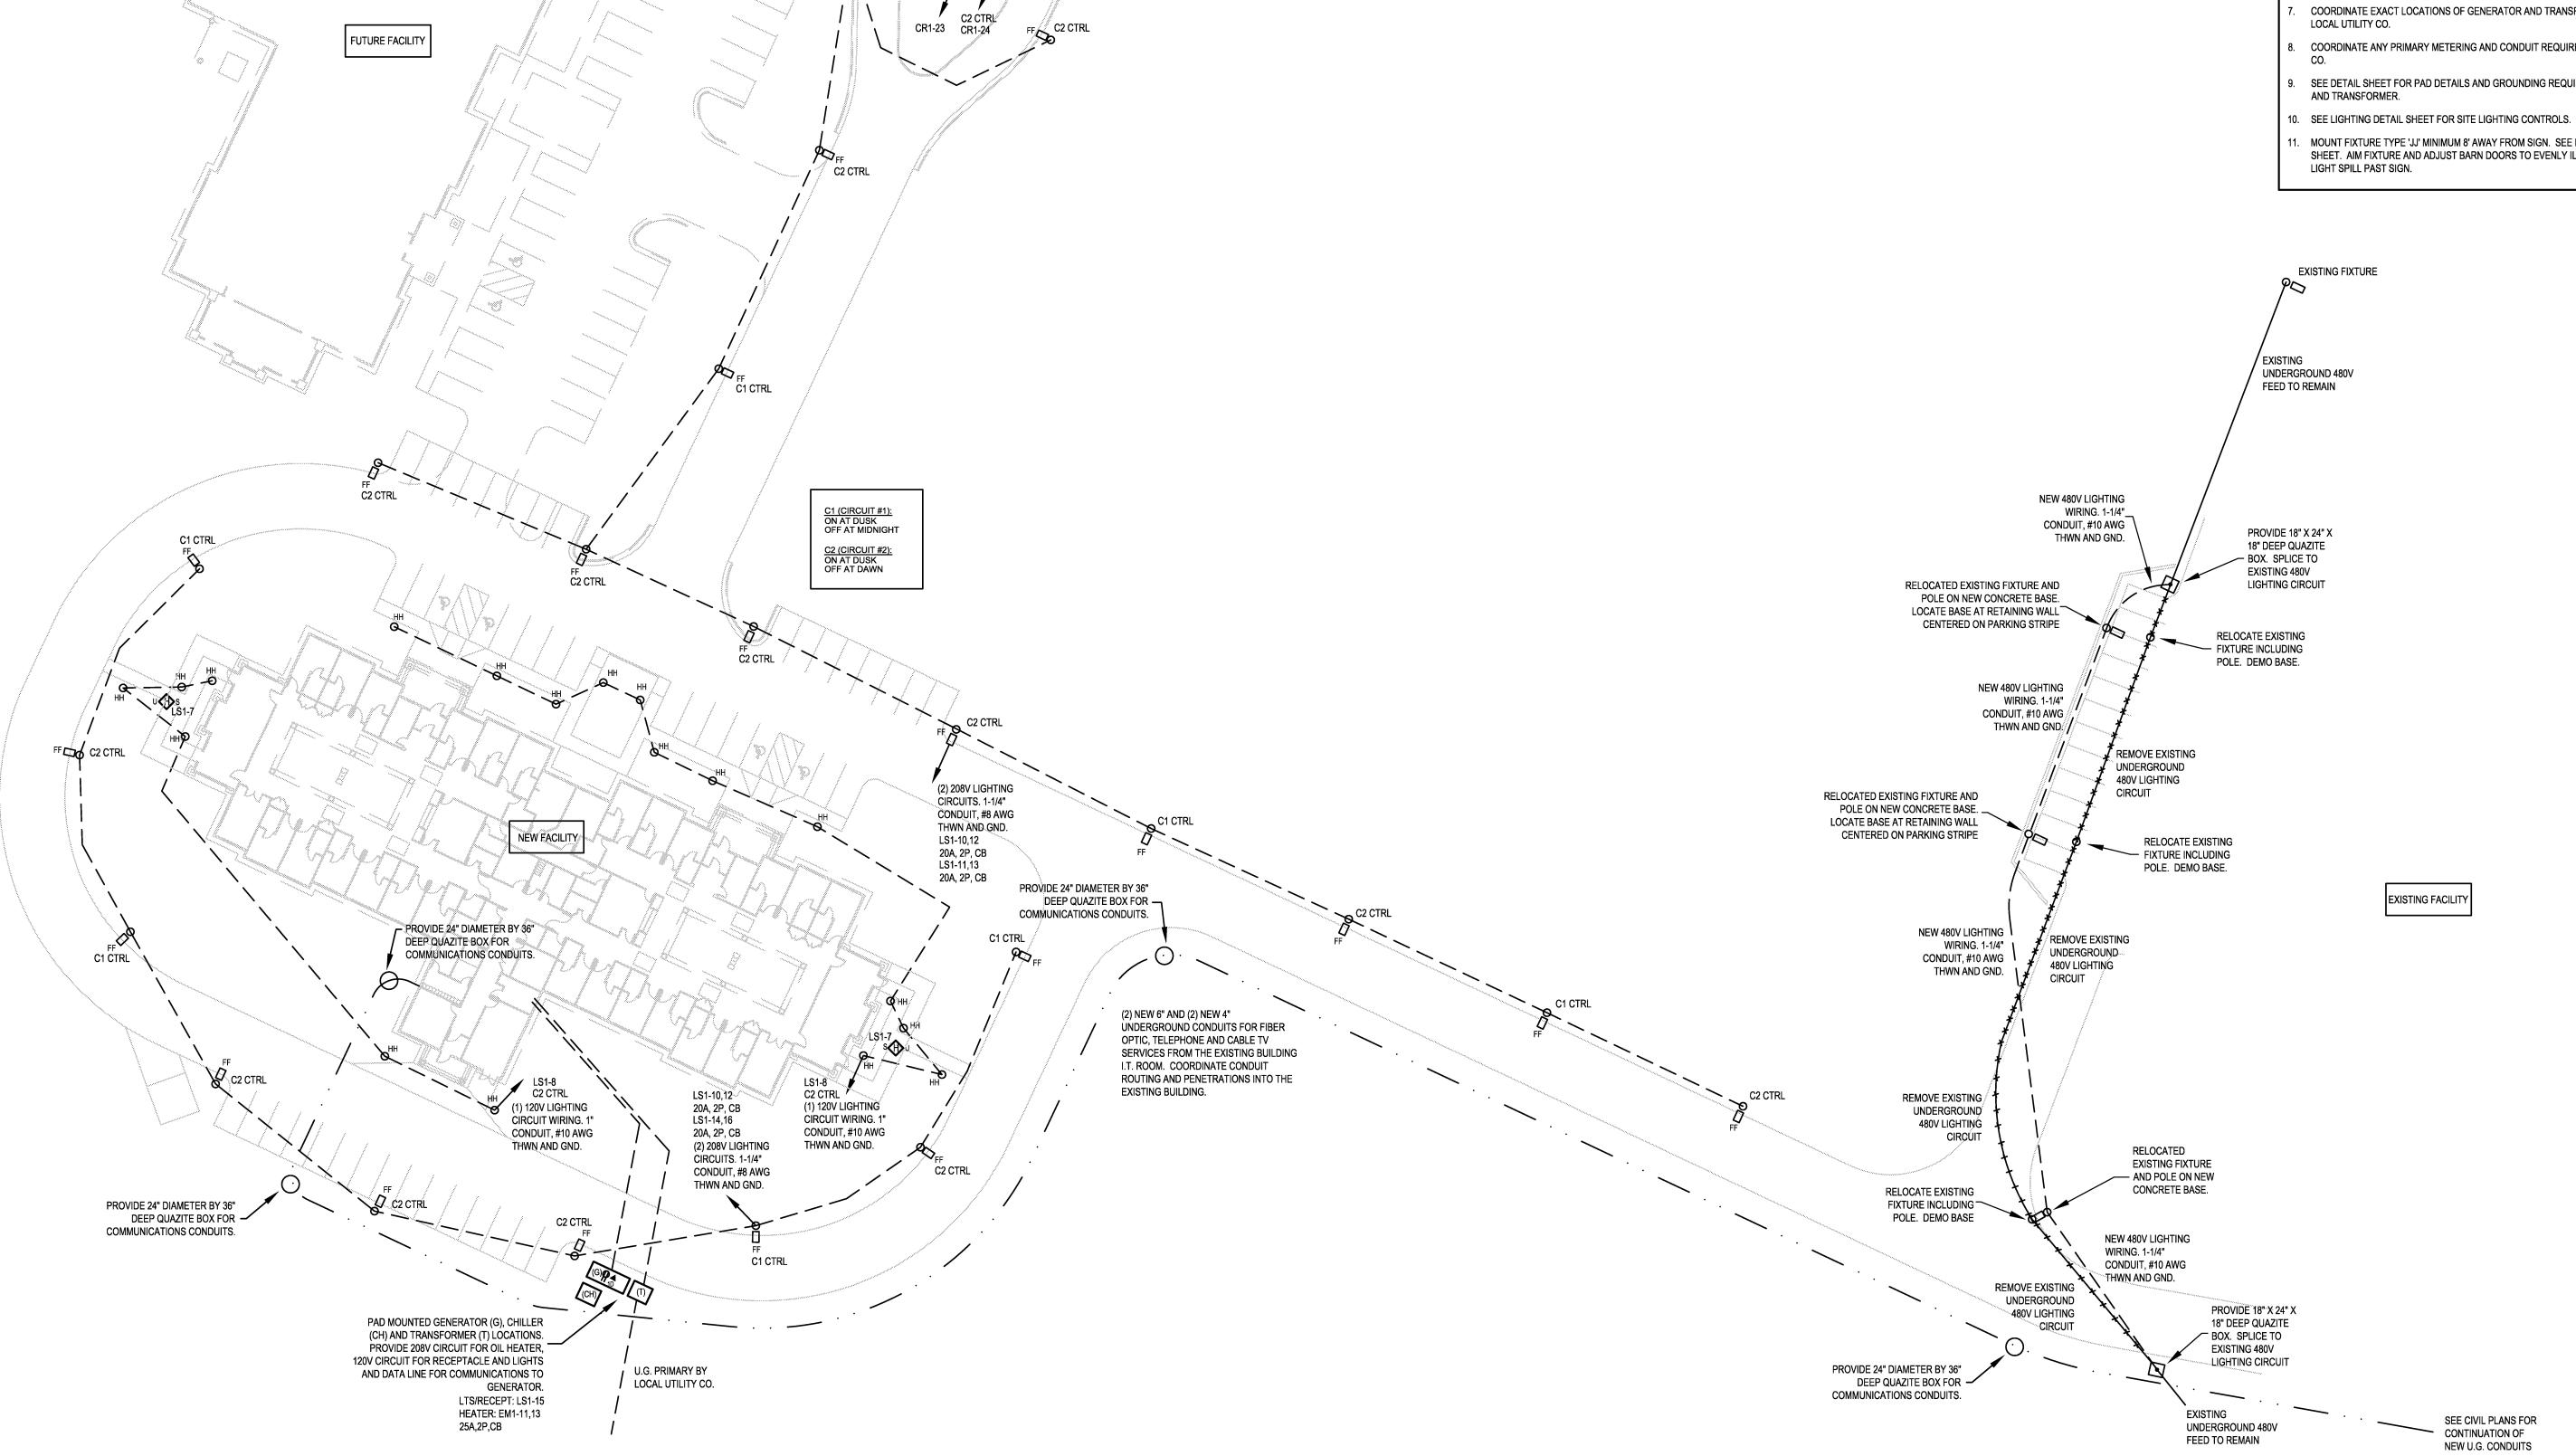

(1) 120V LIGHTING CIRCUIT AND (1)

120V RECEPTÀCLE

CIRCUIT. WIRING. 1"

CONDUIT, #10 AWG

THWN AND GND.

SITE PLAN
SCALE: 1"=30'-0"

02/21/12 ISSUED FOR BIDS

0

.

.

.

.

.

.

• • • •

• • • •

. . . .

• • • •

• • • •

• • • •

• • • •

• • • •

. . . .


. CONSTRUCTION MANAGER

CM CONTRACTING

STRUCTURAL ENGINEER

JDH ENGINEERING

FOOD SERVICE CONSULTANT
MILLIS & ASSOCIATES

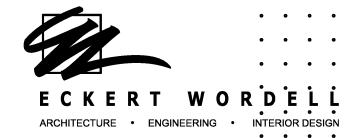

161 East Michigan Ave, Suite 200 Kalamazoo, MI 49007-3907 **PHONE:** 269.388.7313 © 2011 Eckert Wordell, LLC